


- SHEET NOTES -

- 1 WALL HUNG HVAC UNIT (LOCATION MAY VARY)
- 2 THERMOSTAT @ +60" SEALED + 48" UNSEALED (LOCATION MAY VARY)
- 3 MAIN RUNNER TYP
- 4 CROSS RUNNER TYP
- 5 INTERIOR LIGHT FIXTURE REFER TO SHEET E1 FOR SPEC'S
- 6 CEILING HEIGHT @ 8'-6" NOM
- 7 SPLY WIRE SEE 4/M2 FOR DETAILS
- 8 FIXED CEILING END
- 9 FREE CEILING END
- 10 CENTER SECTION THAT CROSSES MODULE LINE TO BE FIELD INSTALLED
- 11 NOT USED
- 12 CONCEALED SUPPLY AIR DUCT ABOVE T-BAR CEILING
- 13 TYPICAL 4-WAY SUPPLY AIR REGISTER LOCATION AND SIZE MAY VARY PER CEILING LAYOUT AND BUILDING SIZE


NOTE:  
 WHERE TWO OR MORE HVAC UNITS SERVE A COMMON SPACE, UNITS SHALL BE EQUIPPED WITH DUCT SMOKE DETECTOR FOR AUTO SHUTDOWN. INTERCONNECT WITH FIRE ALARM SYSTEM  
 AUTOMATIC SHUT-OFF IS NOT REQUIRED WHEN ALL OCCUPIED ROOMS SERVED BY THE AIR HANDLING EQUIPMENT HAVE DIRECT ACCESS TO THE EXTERIOR AND THE TRAVEL DISTANCE DO NOT EXCEEDS 100 FT. PER CMC 609 EXCEPTION #2

MODULE SCHEDULE

BLDG SIZE (FT)	TOTAL # OF 10' WIDE MODULES	"A" TOTAL # OF CENTER MODULES	"B" TOTAL BLDG WIDTH
30x32	3	1	30'-0 1/2"
40x32	4	2	40'-0 3/4"
50x32	5	3	50'-1"
60x32	6	4	60'-1 1/4"
70x32	7	5	70'-1 1/2"
80x32	8	6	80'-1 3/4"
90x32	9	7	90'-2"
100x32	10	8	100'-2 1/4"
110x32	11	9	110'-2 1/2"
120x32	12	10	120'-2 3/4"

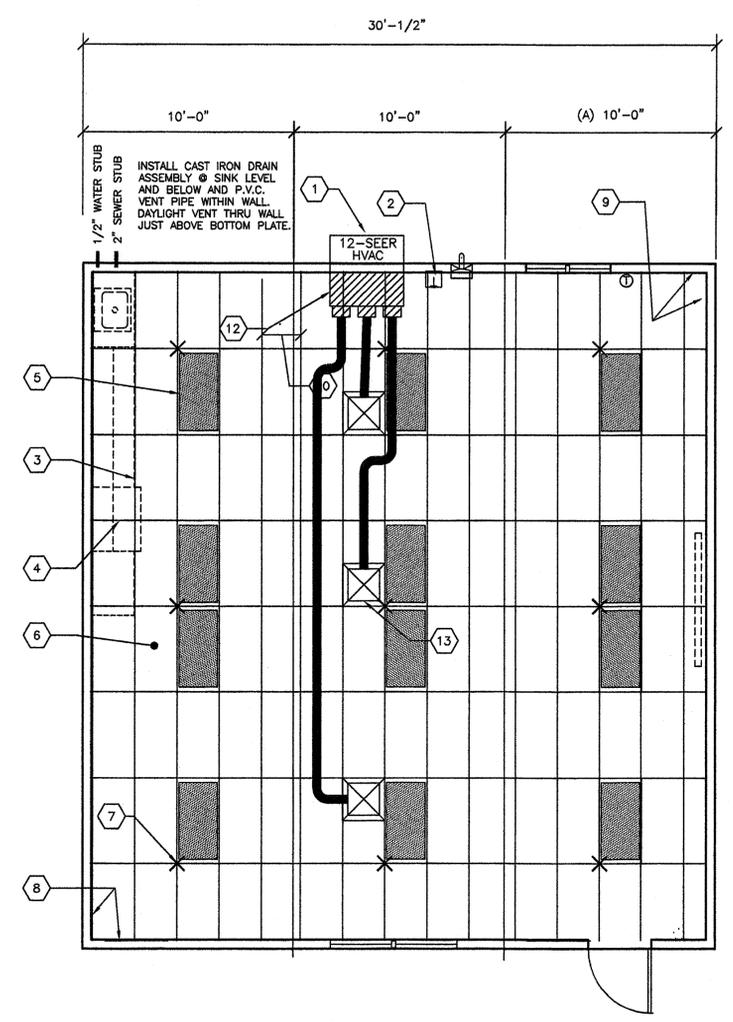

1 TYPICAL REFLECTED CEILING PLAN  
 M1 1/4"=1'-0"

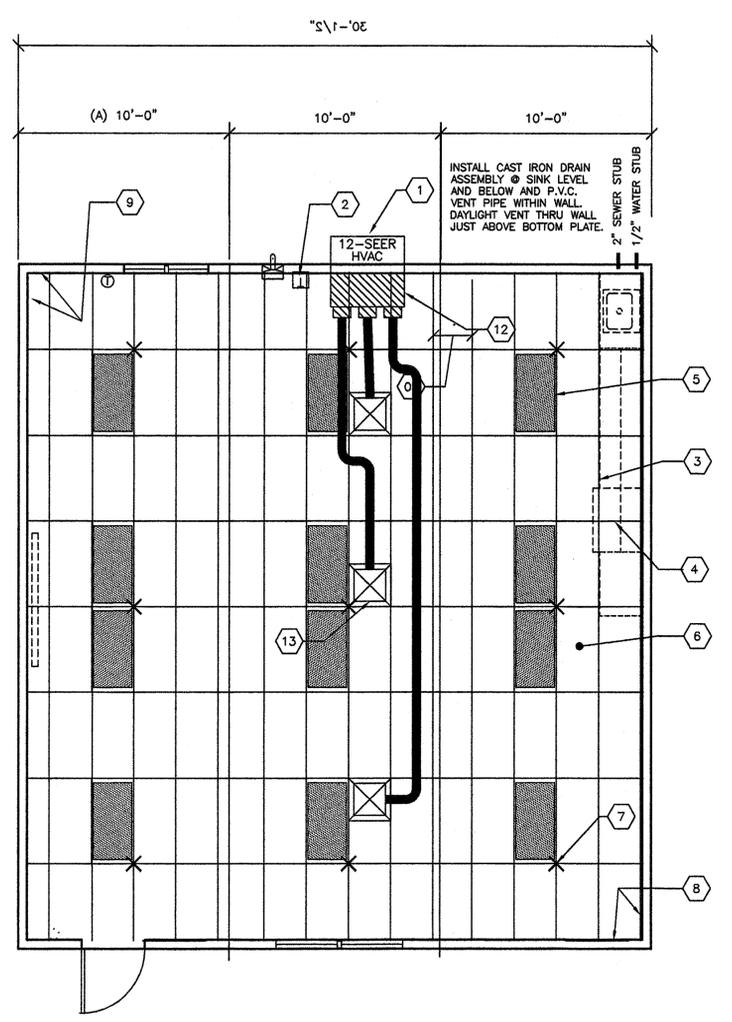

2 TYPICAL REFLECTED CEILING PLAN  
 M1 1/4"=1'-0"

REVISIONS

NO	DATE	DESCRIPTION


DATE: 07/02/09  
 SCALE: NOTED  
 DRAWN BY: MP  
 SERIAL NO.:

CUSTOMER:  
 BAKERSFIELD CITY SCHOOL DISTRICT  
 FREMONT ELEMENTARY SCHOOL

2 1/2:12 PITCHED ROOF 30' x 32' RELOCATABLE BUILDINGS  
 TYPICAL REFLECTED CEILING PLAN



APPROVALS:

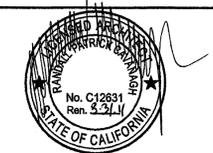

IDENTIFICATION STAMP  
 DIV. OF THE STATE ARCHITECT  
 OFFICE OF REGULATION SERVICES  
 03 112884  
 AC, FLS, SS  
 DATE 8-18-09

IDENTIFICATION STAMP  
 DIV. OF THE STATE ARCHITECT  
 OFFICE OF REGULATION SERVICES  
 AC, FLS, SS  
 DATE

PROJECT No.  
**M1**

BASED ON PC# 02-109701

THESE DRAWINGS AND SPECIFICATIONS ARE THE PROPERTY OF AMERICAN MODULAR SYSTEMS, INC. AND ARE NOT TO BE REPRODUCED, CHANGED OR COPIED IN ANY FORM OR MANNER, NOR ARE THEY TO BE ASSIGNED TO ANY THIRD PARTY WITHOUT THE WRITTEN AUTHORIZATION OF AMERICAN MODULAR SYSTEMS, INC.