
# SITE IMPROVEMENTS FOR (1) - 24'x40' MODULAR CLASSROOM AT: HORACE MANN ELEMENTARY SCHOOL

2710 NILES ST, BAKERSFIELD, CA 93306

BAKERSFIELD CITY SCHOOL DISTRICT 1300 BAKER STREET, BAKERSFIELD, CALIFORNIA, 93305

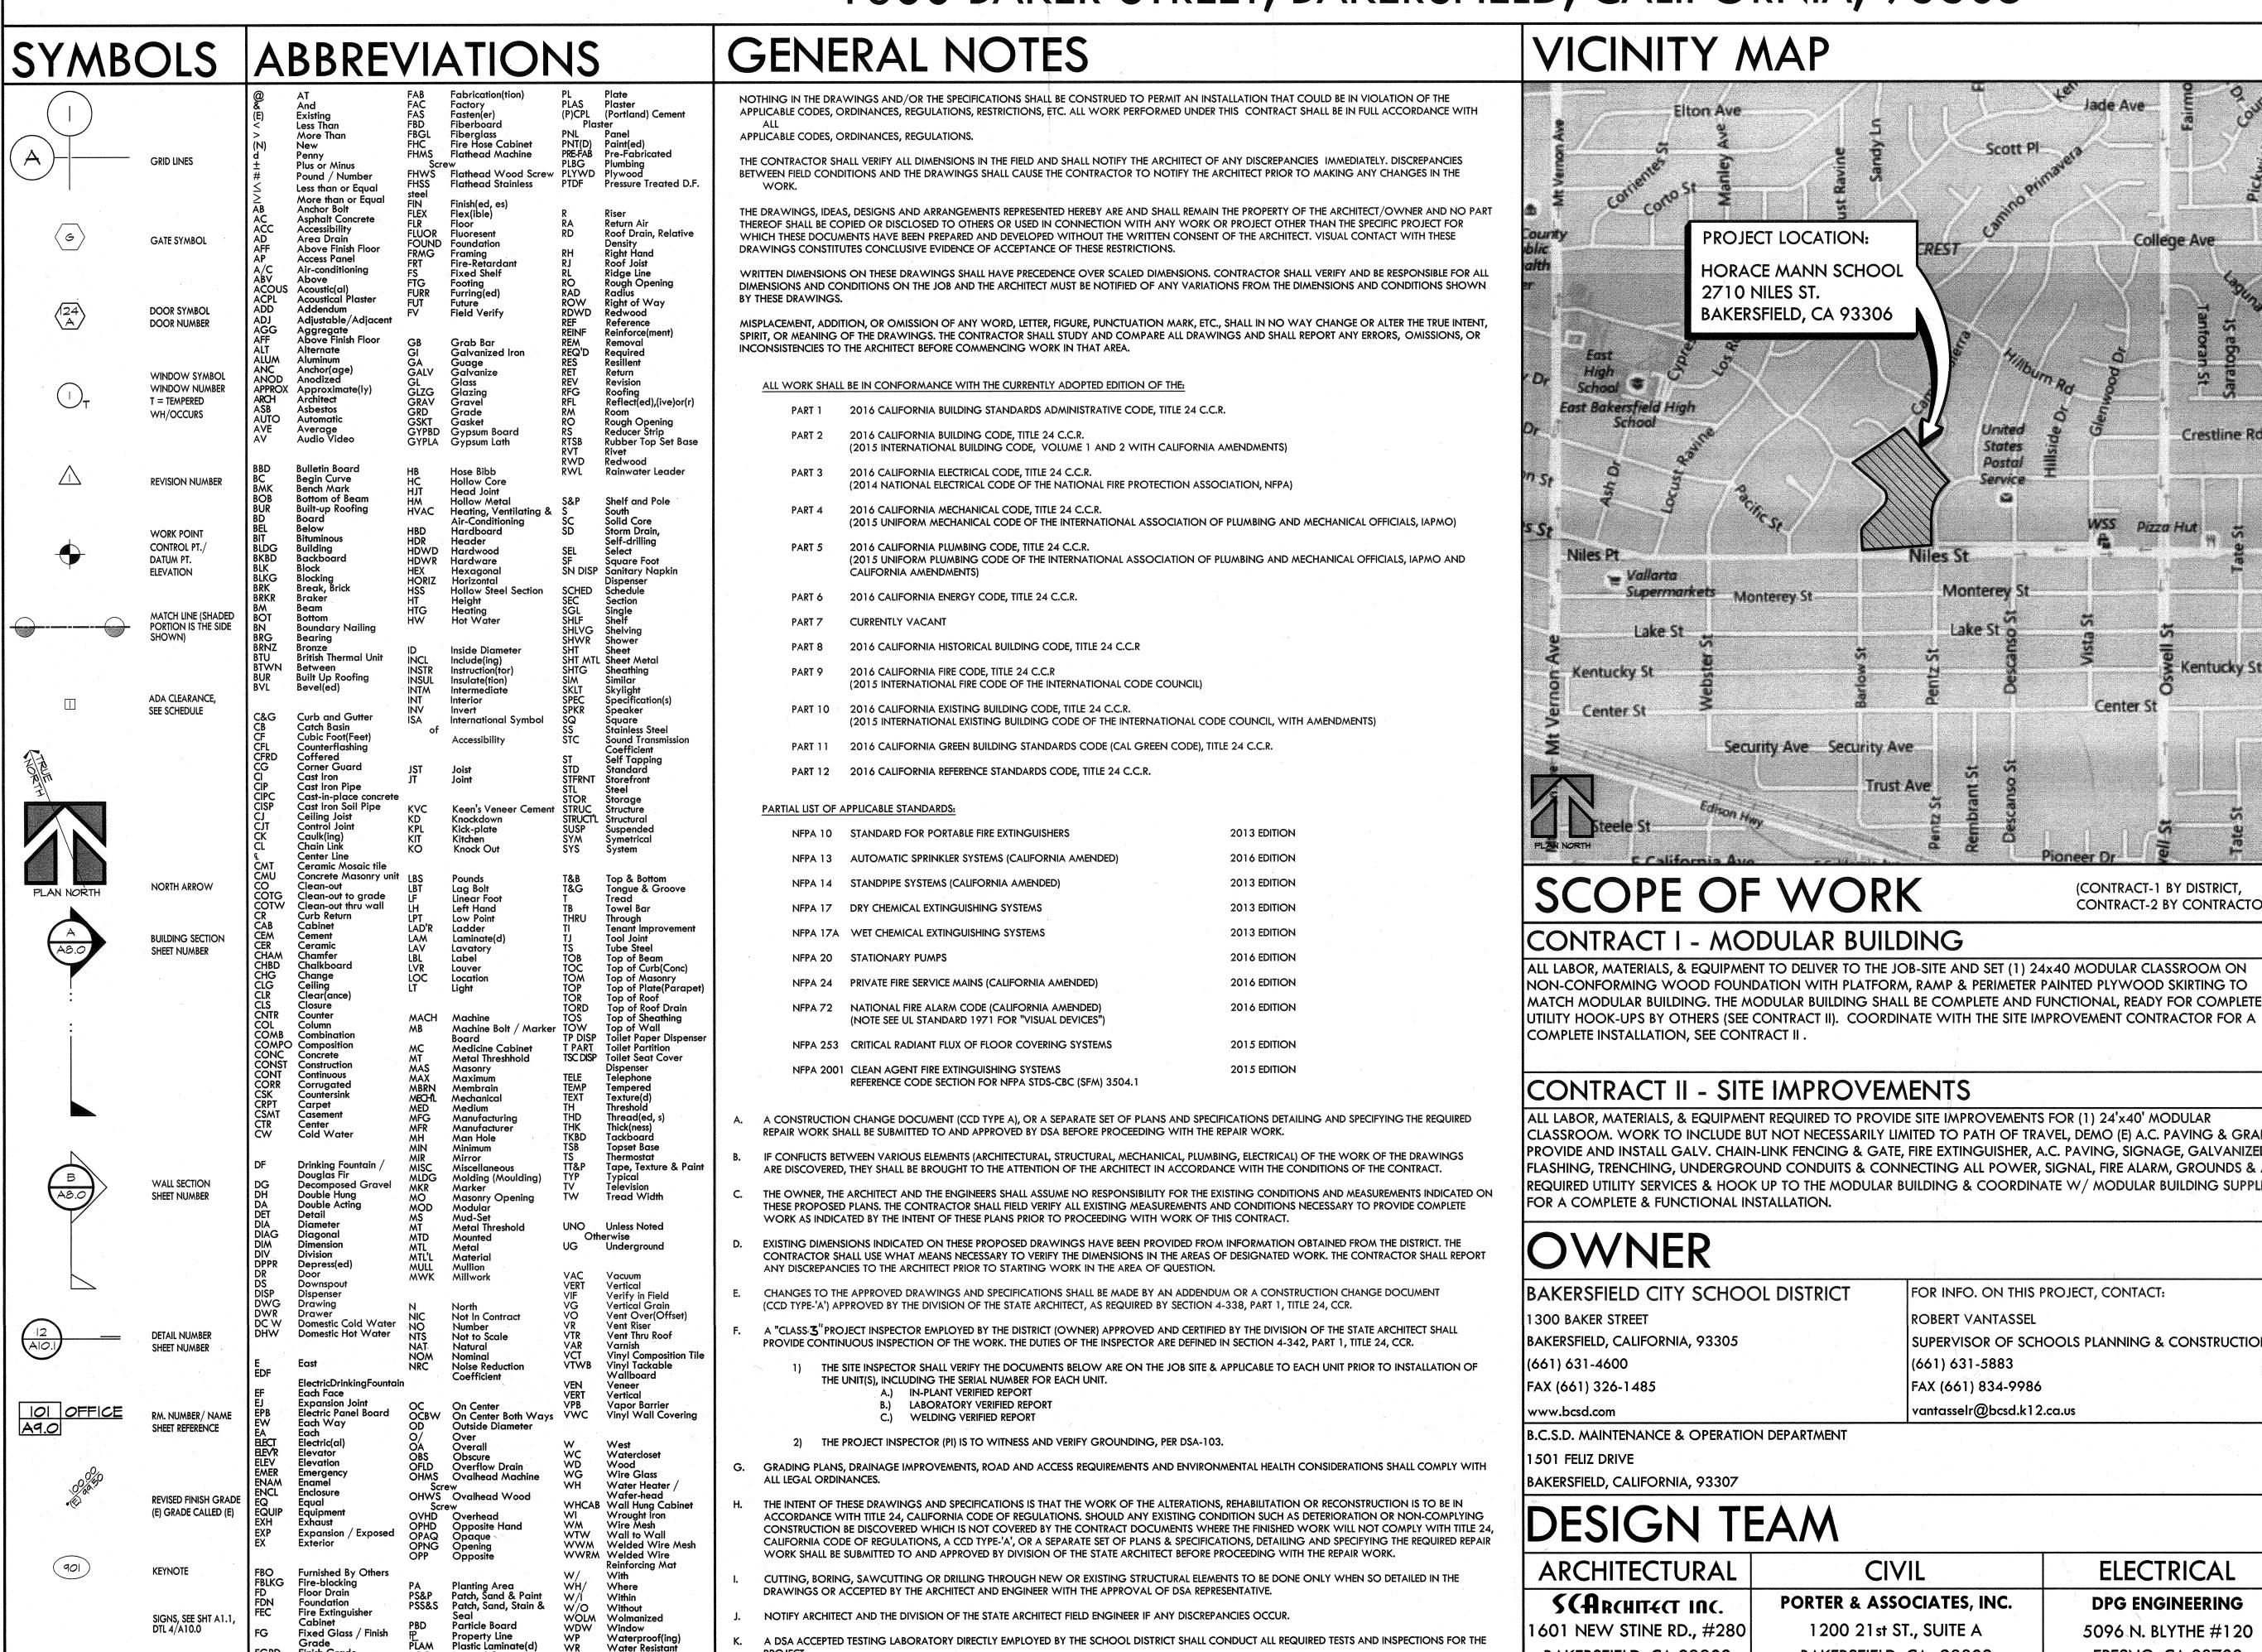

Weatherstrip

PROCEEDING WITH THE REPAIR WORK

DETERIORATION OR EXISTING NON-COMPLAINT CONSTRUCTION: IF ANY CONDITION IS DISCOVERED WHICH, IF LEFT UNCORRECTED, WOULD MAKE THE

MUST BE CORRECTED IN ACCORDANCE WITH CURRENT CODE REQUIREMENTS. A CONSTRUCTION CHANGE DOCUMENT (CCD), OR A SEPARATE SET OF PLANS AND SPECIFICATIONS DETAILING AND SPECIFYING THE REQUIRED REPAIR WORK SHALL BE SUBMITTED TO AND APPROVED BY DSA BEFORE

BUILDING NON-COMPLIANT WITH THE REQUIREMENTS OF THE EDITION OF THE CBC IN FORCE AT THE TIME OF ORIGINAL CONSTRUCTION, THE CONDITION

Flush Joint Face Of

Face of Concrete /

Face of Masonry

PCCONC Precast Concrete

FOC

KITCHEN EQUIPMENT

# PROJECT LOCATION: HORACE MANN SCHOOL 2710 NILES ST. BAKERSFIELD, CA 93306 Kentucky St. Kentucky St

## SCOPE OF WORK

Security Ave Security Ave

(CONTRACT-1 BY DISTRICT, CONTRACT-2 BY CONTRACTOR ) CONTRACT I - MODULAR BUILDING

#### ALL LABOR, MATERIALS, & EQUIPMENT TO DELIVER TO THE JOB-SITE AND SET (1) 24x40 MODULAR CLASSROOM ON NON-CONFORMING WOOD FOUNDATION WITH PLATFORM, RAMP & PERIMETER PAINTED PLYWOOD SKIRTING TO

COMPLETE INSTALLATION, SEE CONTRACT II CONTRACT II - SITE IMPROVEMENTS ALL LABOR, MATERIALS, & EQUIPMENT REQUIRED TO PROVIDE SITE IMPROVEMENTS FOR (1) 24'x40' MODULAR

CLASSROOM. WORK TO INCLUDE BUT NOT NECESSARILY LIMITED TO PATH OF TRAVEL, DEMO (E) A.C. PAVING & GRADE. PROVIDE AND INSTALL GALV. CHAIN-LINK FENCING & GATE, FIRE EXTINGUISHER, A.C. PAVING, SIGNAGE, GALVANIZED FLASHING, TRENCHING, UNDERGROUND CONDUITS & CONNECTING ALL POWER, SIGNAL, FIRE ALARM, GROUNDS & ALI REQUIRED UTILITY SERVICES & HOOK UP TO THE MODULAR BUILDING & COORDINATE  ${\sf W/MODULAR}$  BUILDING SUPPLIER FOR A COMPLETE & FUNCTIONAL INSTALLATION.

300 BAKER STREET BAKERSFIELD, CALIFORNIA, 93305 661) 631-4600 FAX (661) 326-1485

ROBERT VANTASSEL SUPERVISOR OF SCHOOLS PLANNING & CONSTRUCTION (661) 631-5883 FAX (661) 834-9986

FOR INFO. ON THIS PROJECT, CONTACT:

vantasselr@bcsd.k12.ca.us

Center 5

3.C.S.D. MAINTENANCE & OPERATION DEPARTMENT 1501 FELIZ DRIVE

### DESIGN TEAM

ARCHITECTURAL	CIVIL	ELECTRICAL
SCARCHITECT INC.	PORTER & ASSOCIATES, INC.	DPG ENGINEERING
1601 NEW STINE RD., #280	1200 21st ST., SUITE A	5096 N. BLYTHE #120
BAKERSFIELD, CA 93309	BAKERSFIELD, CA 93309	FRESNO, CA 93722
(661) 397-4377	(661) 327-0362	(559) 276-5144
FAX (661) 397-4378	FAX (661) 327-1065	FAX (559) 276-5767
scorbin@scarchitect.com	mattc@portercivil.com	davor@dpgengineering.com

### SHEET INDEX

C1 CIVIL IMPROVEMENTS R-16 CLASSROOM, ADA PATH OF TRAVEL **ARCHITECTURAL** 

A1.0 'A'-SITE PLAN / SCHOOL DIRECTORY

A10.0 MISCELLANEOUS DETAILS

**ELECTRICAL** 

RELOCATED MODULAR BUILDINGS FROM STOCKPILE REQUIREMENTS OF TITLE 24, CALIFORNIA CODE OF REGULATIONS AND THE PROJECT SPECIFICATIONS BY ME. THE ITEMS LISTED BELOW HAVE BEEN COORDINATED WITH MY PLANS AND SPECIFICATIONS AND ARE ACCEPTABLE DESIGNATED TO BE GENERALLY RESPONSIBLE (OR FOR WHICH I HAVE BEEN DELEGATED RESPONSIBILITY). À LIST

FALL DRAWINGS ARE ATTACHED, THEY HAVE BEEN REVIEWED & ACCEPTED SEE SHEET-0, TITLE SHEET OF I SHALL BE RESPONSIBLE TO VERIFY BY APPROPRIATE MEANS SUBJECT TO DSA APPROVAL, THAT THE MODULAR BUILDINGS TO BE RELOCATED FOR THIS APPLICATION SHALL CONFORM TO THE ORIGINALLY APPROVED PLANS & SPECIFICATIONS & HAVE NOT BEEN ALTERED STRUCTURALLY OR SUFFERED STRUCTURAL DETERIORATION.



#### AURORA MODULAR INDUSTRIES

Modular Building BUILDING R16

SN-19563-19564; STOCKPILE A-65839; PC-253 COVER SHEET, SHEET INDEX, BUILDING DATA

FLOOR PLAN, ROOF PLAN, BUILDING ELEVATIONS FLOOR FRAMING, ROOF FRAMING, STRUCTURAL ELEVATIONS REFLECTED CEILING PLAN

AIR CONDITIONING FLOOR PLAN

ELECTRICAL POWER & LIGHTING FLOOR PLAN & PANEL SCHEDULE RAMP PLAN AND DETAILS Wood Foundation

#### **ELITE MODULAR** BUILDING R16

WF-04 WOOD FOUNDATION PLAN

WFD-01 FOUNDATION DETAILS - WOOD

# This drawing or page

is/are in general conformance with the project design is/are in general conformance with the project design

Architect or Engineer delegated responsibility

All drawings or sheets listed on the cover or index sheet

has/have been coordinated with the project plans and

for this portion of the work


## GENERAL NOTES CONTINUED


Specifications do not override construction drawings. Submit RFIs to design team if there are discrepancy between approved drawings and approved specifications. Submit revised drawings or specifications as result of such RFIs to DSA via CCDs if required by IR A-6. N. TITLE 24 PART 1-5 & 9 MUST BE ON SITE DURING CONSTRUCTION.

### SITE DATA

CLIMATE ZONE 110 imph SEISMIC DESIGN FACTOR. SEISMIC IMPORTANCE FACTOR. 3-SECOND GUSTS.... WIND EXPOSURE. OPOGRAPHIC FACTOR... SOIL BEARING PRESSURE..


MARK | DATE | REVISIONS

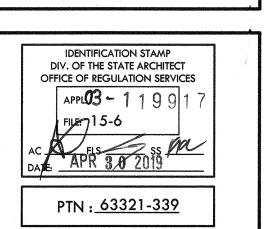

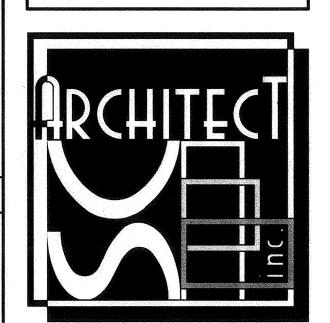

1601 NEW STINE ROAD, SUITE 280 PH: (661) 397-4377 FAX: (661) 397-4378 WWW.SCARCHITECT.COM



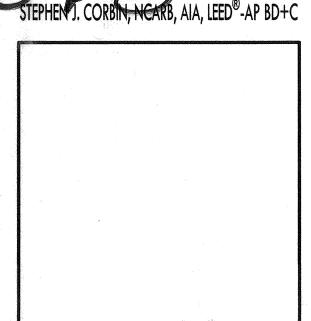

SCOPE OF WORK GENERAL NOTES **ABBREVIATIONS** 

JOB NO. DRAWN: CHECKED SJC

11/19/18

